




100	SWITCHGEAR ROOM
101	BATTERY ROOM
102	TRANSFORMER SHELTER

D00	SEP.2023	IFC	K.AHMADI	M.FAKHARIAN	S.FARAMARPOUR	
REV.	REV. DATE P.O.I.S		PREP.	СНК.	APP.	
PROJECT NAME: BINAK OILFIELD DEVELOPMENT/SUB-SURFACE WORK PACK BK05 WHF MODIFICATIONS				CK		
PROJECT	NO.:		97102	20		
EPC CONT	EPC CONTRACTOR: EPD/EPC CONTRACTOR (GC):					-
HIRGAN PETRO					TROIRAN	
					VELOPME	N
HIRGAN		DESIGN & INSPECTION PANIES	PEDC	0 CO	MPANY	
DRAWING	TITLE:					
PLUI	MBING & S	EWAGE PIPING LAYOUT	FOR SWITC	CHGEAR BU	ILDING – I	3K
SCALE	SIZE	DRAWIN	IG NO.		SHEET NO	'•
AS SHOWN	A1	BK-BK05-PEDCO-	-110-HV-PY	-0003	01 OF 02	
1	<u>I</u>					

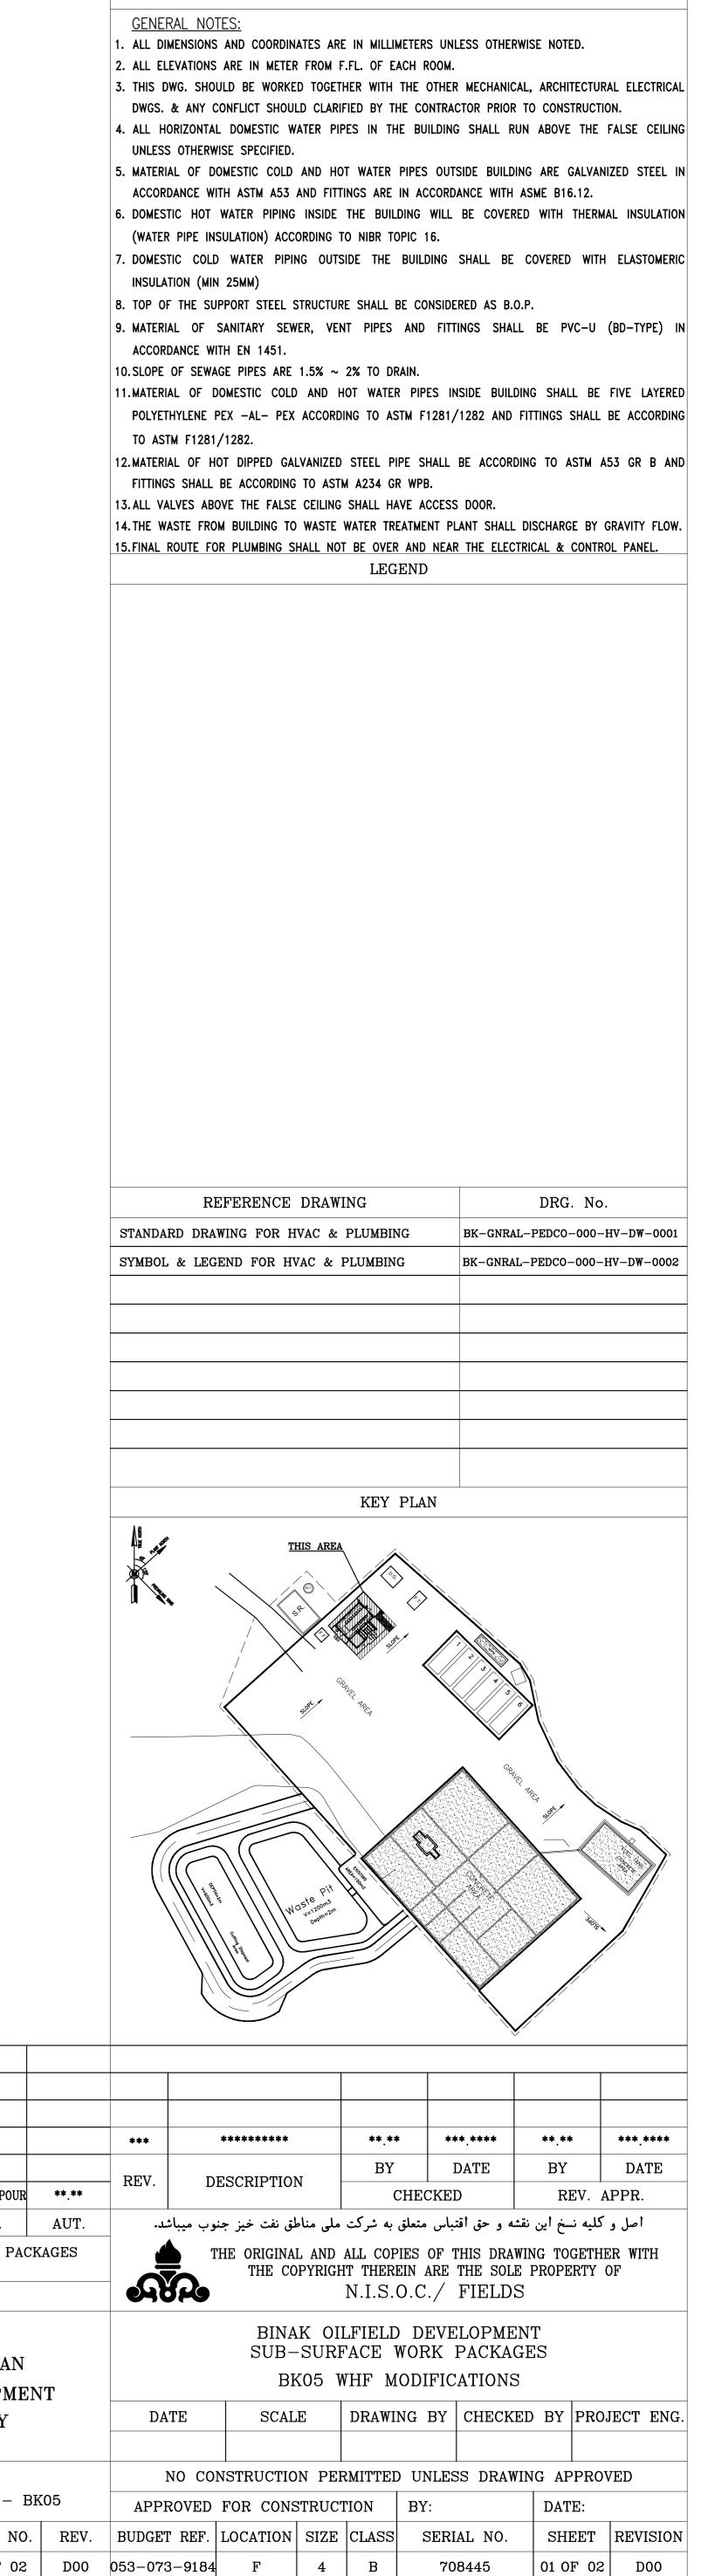

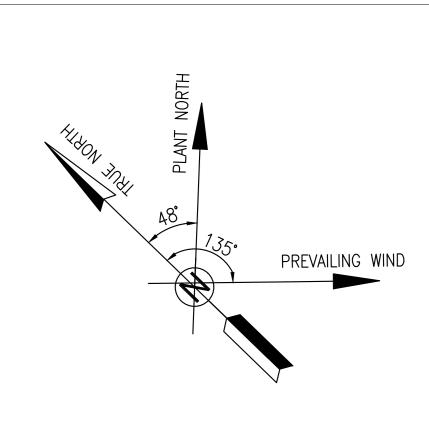

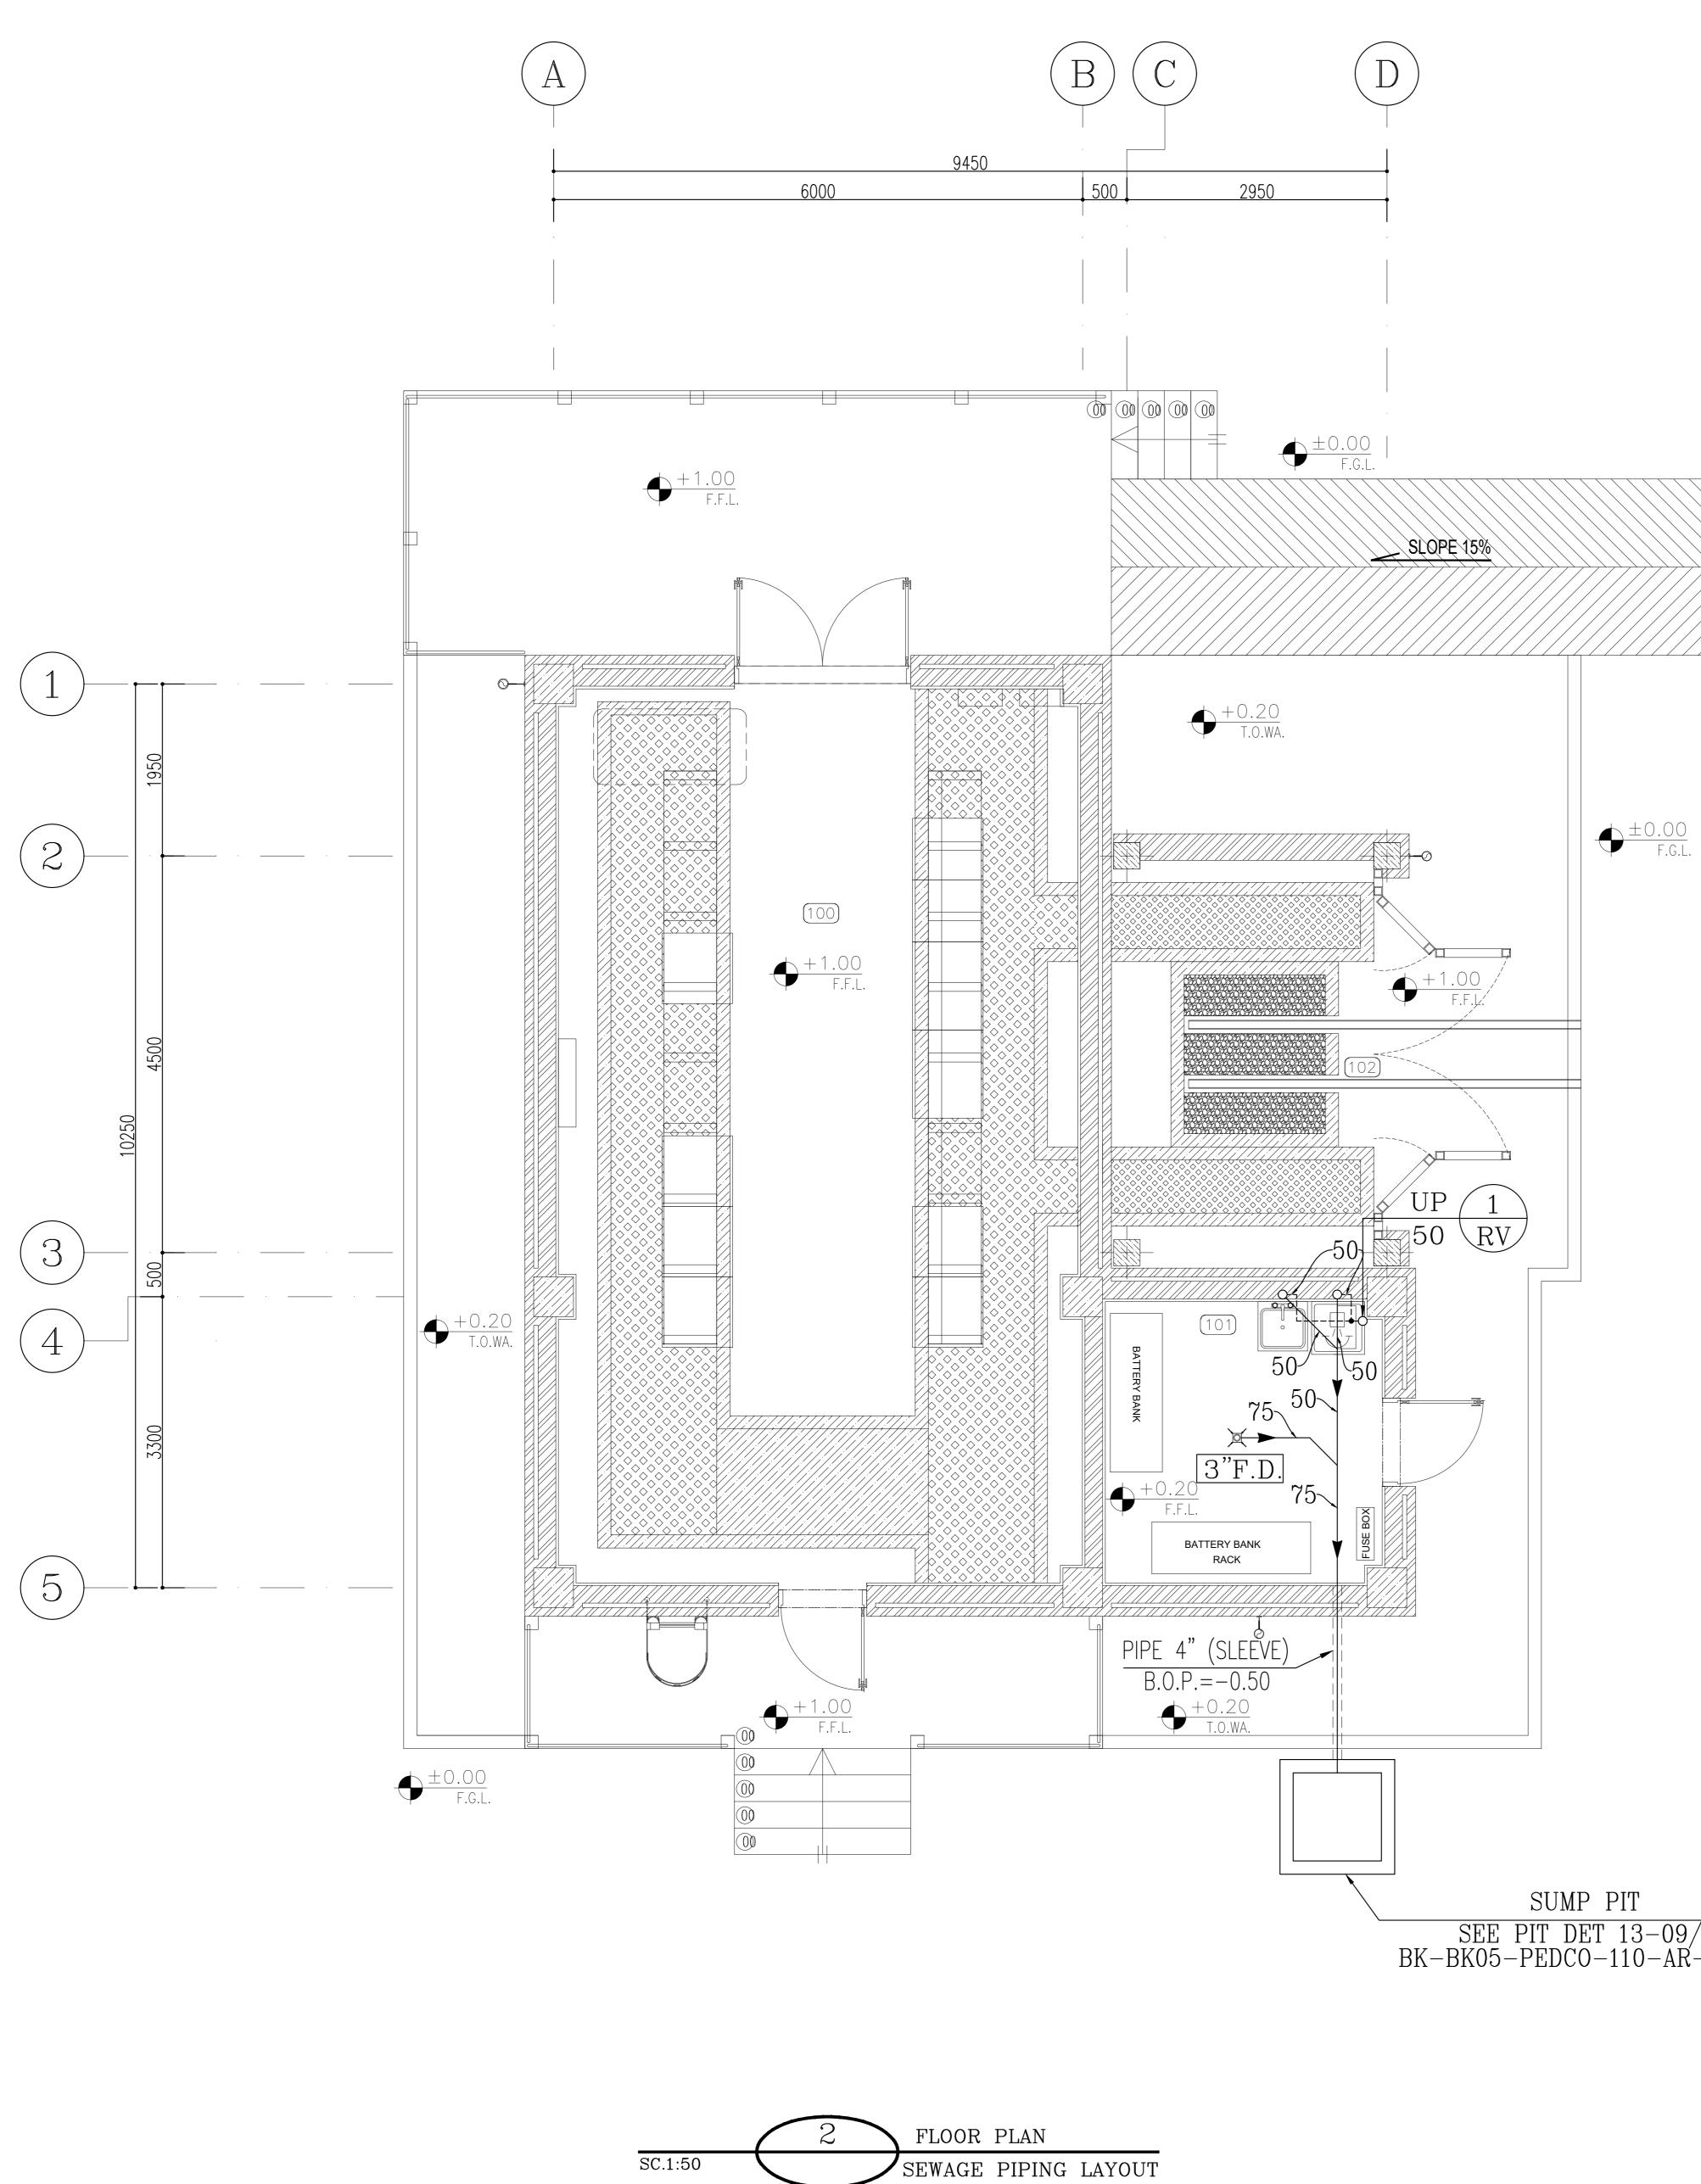

SUMP PIT							
SEE PIT DET 13-09/14 -BK05-PEDC0-110-AR-DW-0002	D00	SEP.2023	IFC	K.AHMADI	M.FAKHARIAN	S.FARAMARPOUR	
-BK03-PEDC0-110-AK-DW-000%	REV.	DATE	P.O.I.S	PREP.	CHK.	APP.	
	PROJECT	NAME:	BINAK OILFIELD DEVE	LOPMENT/SU K05 WHF MO	UB-SURFAC	E WORK PAG	CKA
	PROJECT	NO.:		97102	50		
	EPC CON	TRACTOR:		EPD/EPC	CONTRACTO	OR (GC):	
		HIRGA		C		TROIRAN VELOPME	
	HIRGAN		DESIGN & INSPECTION PANIES	PEDC	о СО	MPANY	
	DRAWING	TITLE:					
	PLU	MBING & S	EWAGE PIPING LAYOUT	FOR SWITC	CHGEAR BU	ULDING – I	BKC
	SCALE	SIZE	DRAWIN	IG NO.		SHEET NO).
	AS SHOWN	A1	BK-BK05-PEDCO-	110-HV-PY	-0003	02 OF 02	;
	1	Į	1			1	

г		
	100	SWITCHGEAR ROOM
	101	BATTERY ROOM
	102	TRANSFORMER SHELTER

